

ELEVATION 3 IS IDENTICAL TO ELEVATION 1  
ELEVATION 4 IS IDENTICAL TO ELEVATION 2

THIS DRAWING IS THE PROPERTY OF NAGPUR METRO RAIL CORPORATION LTD.

**GENERAL NOTES:**

- ALL DIMENSIONS ARE IN MILLIMETERS & LEVELS ARE IN METERS UNLESS OTHERWISE STATED.
- ALL DIMENSIONS ARE TO BE READ AND NOT MEASURED.
- ANY DISCREPANCIES MUST BE BROUGHT TO THE NOTICE OF THE NMRC BEFORE EXECUTION OF WORK AT SITE.
- THIS DRAWING MUST BE READ IN CONJUNCTION WITH ALL RELEVANT ARCHITECTURAL, STRUCTURAL, PLUMBING & FIRE FIGHTING, ELECTRICAL AND TRAFFIC MANAGEMENT DRAWINGS.
- ALL DOOR/WINDOW CILL & LINTEL LEVELS ARE MEASURED FROM MAIN FLOOR FINISHED LEVELS.

**REFERENCE DRAWINGS**

Dwg. No.	Description

**DESCRIPTION OF REVISIONS**

REV.	DESCRIPTION	DATE	NAME	SIGN.

**NO OBJECTION**

**NAGPUR METRO RAIL CORP.LTD.**  
Metro House, 28/2, Anand Nagar, C K Naidu Road, Civil Lines, Nagpur - 440001

DGM / E&M      Sr.DGM / Civil      CPM / RS

THE RESPONSIBILITY OF OVERALL CORRECTNESS OF DESIGN AND DRAWINGS RESTS WITH THE DDC. FORWARDED FOR APPROVAL AND ISSUE OF GOOD FOR CONSTRUCTION DRAWINGS.

(CHIEF ARCHITECT) (PROJECT LEADER)

THIS DRAWING INCLUDING ITS DESIGN AND DETAILING HAS BEEN CHECKED INDEPENDENTLY AND FOUND SUITABLE FOR THE EXECUTION PURPOSE AND ARE RECOMMENDED FOR 'GOOD FOR CONSTRUCTION'.

SIGN: \_\_\_\_\_  
DATE: \_\_\_\_\_  
NAME: \_\_\_\_\_

**GENERAL CONSULTANTS FOR NAGPUR METRO RAIL PROJECT**

Church House, Above SBI Bank, First floor, CK Naidu Marg, Anand Nagar Civil Lines Nagpur - 440001

**SYSTA AECOM egis RITES**

**DETAIL DESIGN CONSULTANT**

**FOUNTAINHEAD**

ARCHITECTURE INTERIOR & LANDSCAPE  
C-9/9148, VASANT KUNJ, NEW DELHI  
PH: 011-26891534, 26124540, 26124543. FAX: 26898459  
Email: office@studiofountainhead.com

VARSHA DESIGNED BY      RENU BALA CHECKED BY      S.M APPROVED BY

**NAGPUR METRO RAIL CORPORATION LTD.**  
Metro House, 28/2, Anand Nagar, C K Naidu Road, Civil Lines, Nagpur - 440001

**N1DDC D-01**

**ROLLING STOCK DEPOT AT MIHAN**




DRAWING TITLE: AUTO COACH WASH PLANT - ELEVATIONS  
NMRC DRAWING NO: N1DDC01-DPOM-GFC-AR-2521

DATE: 05.11.2016      SCALE: 1:50      STATUS: FOR APPROVAL

SHEET NO: \_\_\_\_\_      R0

ARCHITECTURE

This drawing must not be either loaned, copied or otherwise reproduced in whole or in part or used for any purpose without the prior written permission of NMRC.

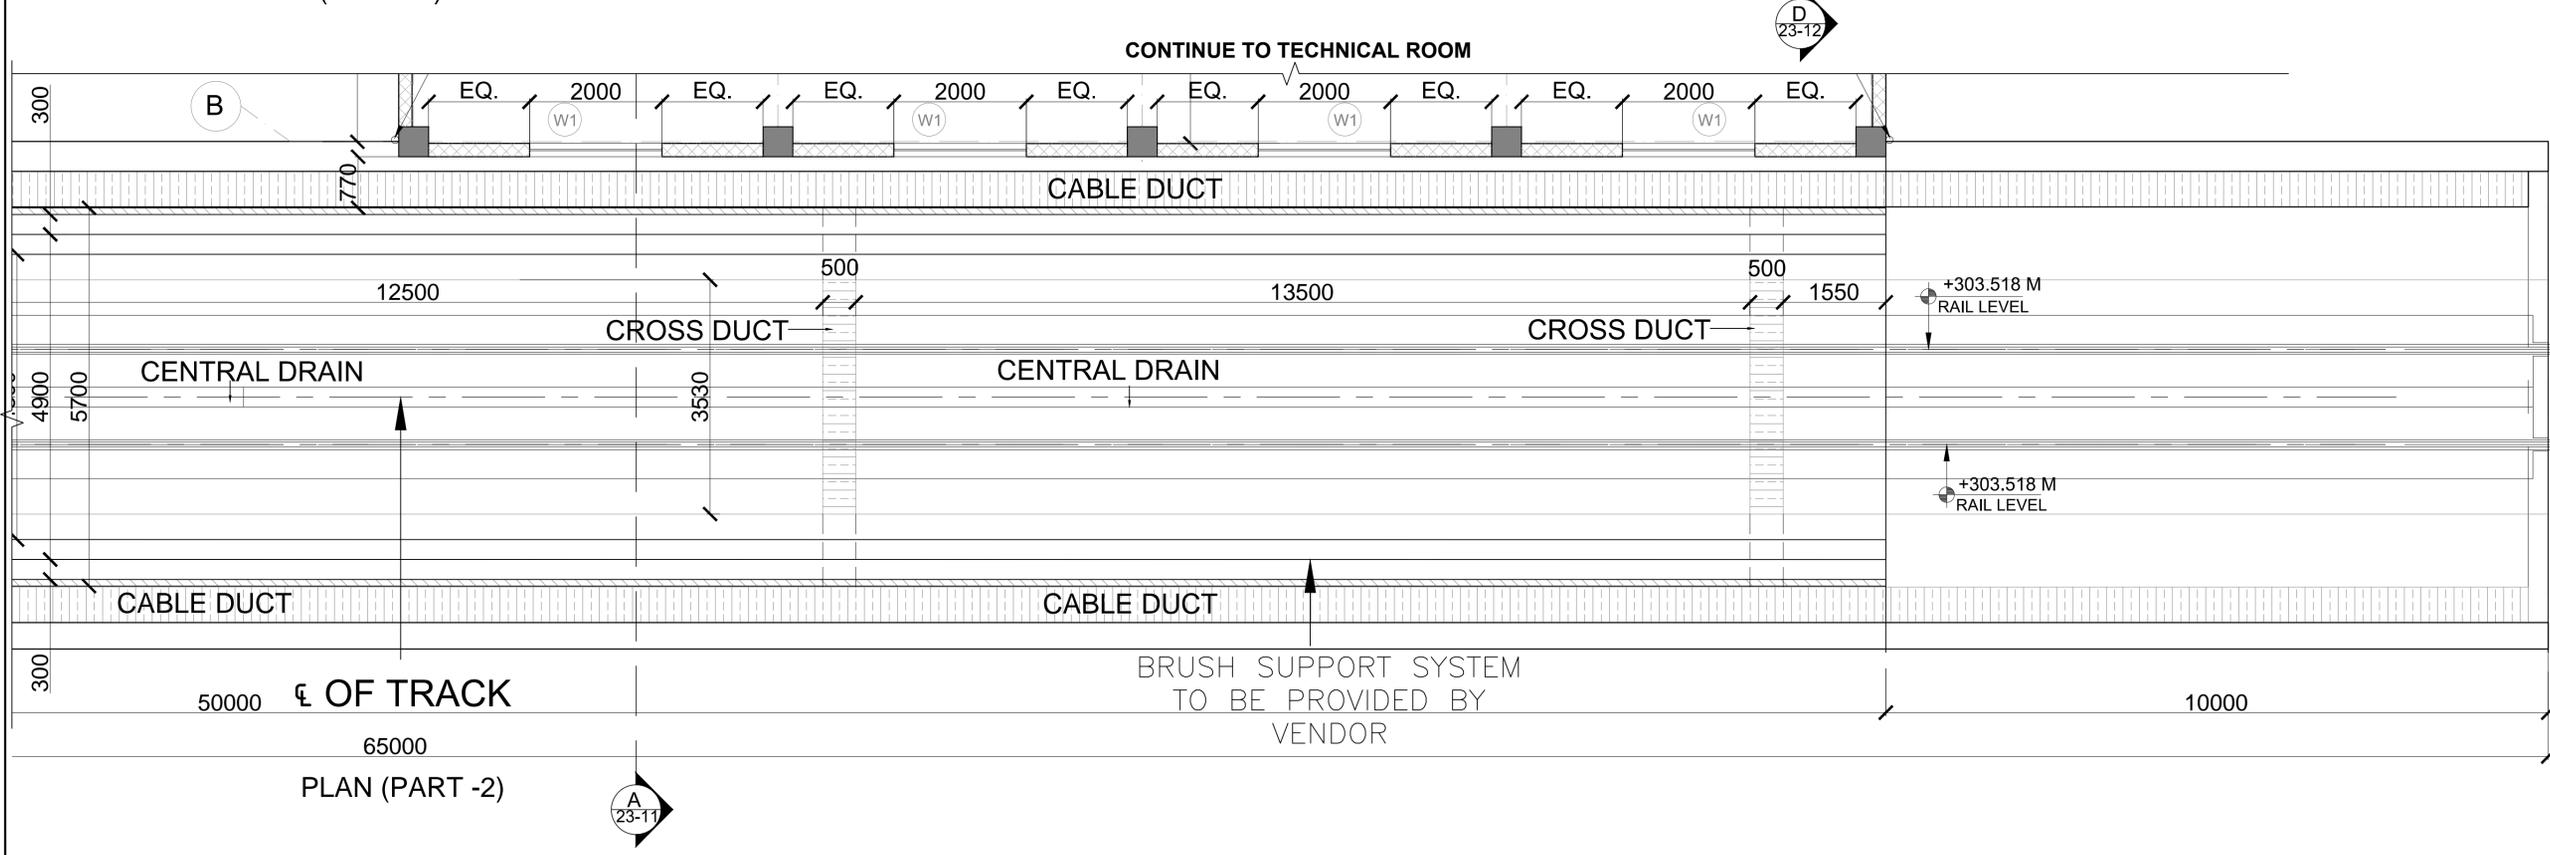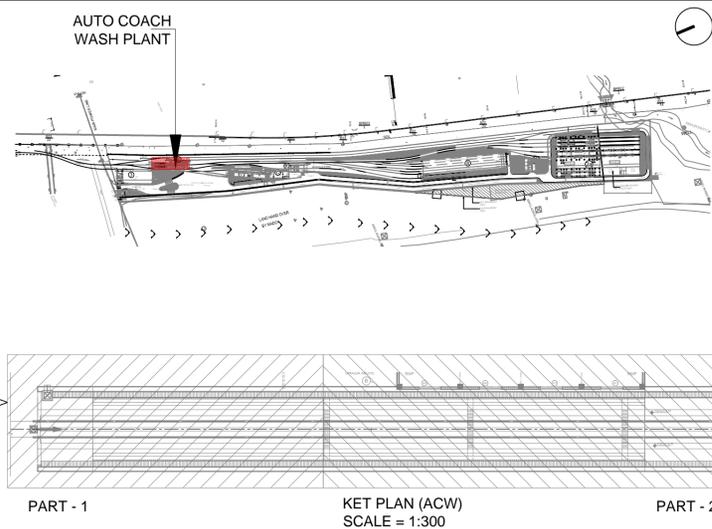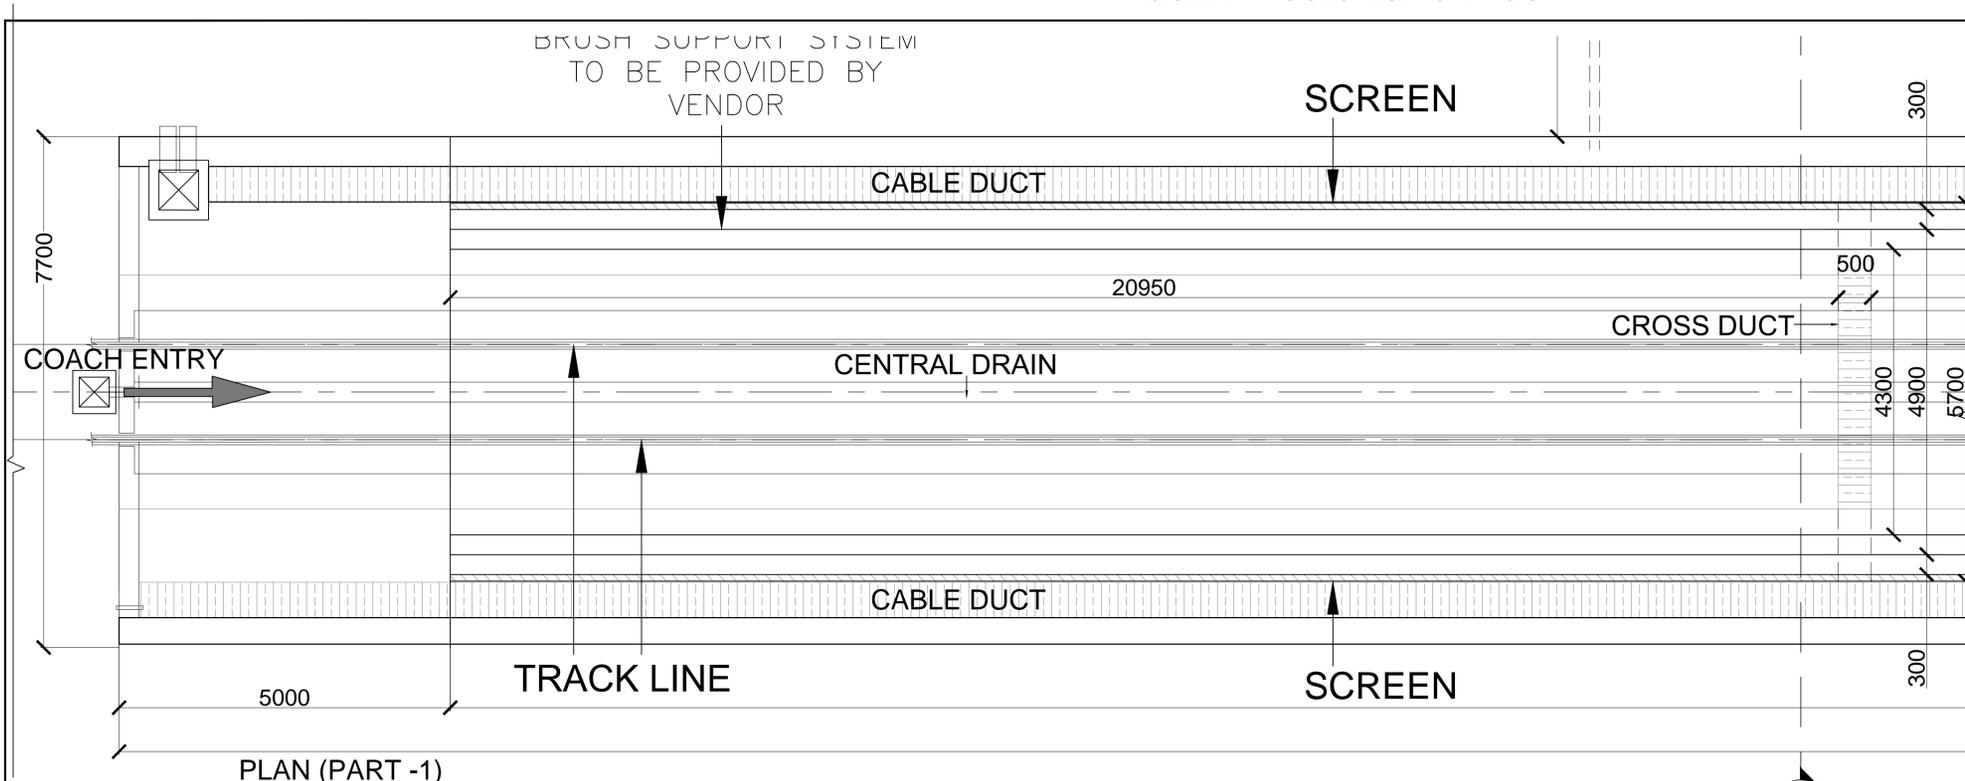

THIS DRAWING IS THE PROPERTY OF NAGPUR METRO RAIL CORPORATION LTD.

GENERAL NOTES:  
 1. ALL DIMENSIONS ARE IN MILLIMETERS & LEVELS ARE IN METERS UNLESS OTHERWISE STATED.  
 2. ALL DIMENSIONS ARE TO BE READ AND NOT MEASURED.  
 3. ANY DISCREPANCIES MUST BE BROUGHT TO THE NOTICE OF THE ARCHITECT BEFORE EXECUTION OF WORK AT SITE.  
 4. THIS DRAWING MUST BE READ IN CONJUNCTION WITH ALL RELEVANT ARCHITECTURAL, STRUCTURAL, PLUMBING & FIRE FIGHTING, ELECTRICAL AND TRAFFIC MANAGEMENT DRAWINGS.  
 5. ALL DOOR/WINDOW CILL & LINTEL LEVELS ARE MEASURED FROM MAIN FLOOR FINISHED LEVELS.

REFERENCE DRAWINGS	
Dwg. No.	Description

DESCRIPTION OF REVISIONS				
REV.	DESCRIPTION	DATE	NAME	SIGN.

**NO OBJECTION**

**NAGPUR METRO RAIL CORP.LTD.**  
 Metro House, 28/2, Anand Nagar, C K Naidu Road, Civil Lines, Nagpur - 440001

DGM / E&M      Sr.DGM / Civil      CPM / RS

THE RESPONSIBILITY OF OVERALL CORRECTNESS OF DESIGN AND DRAWINGS RESTS WITH THE DDC. FORWARDED FOR APPROVAL AND ISSUE OF GOOD FOR CONSTRUCTION DRAWINGS.

(CHIEF ARCHITECT) (PROJECT LEADER)

THIS DRAWING INCLUDING ITS DESIGN AND DETAILING HAS BEEN CHECKED INDEPENDENTLY AND FOUND SUITABLE FOR THE EXECUTION PURPOSE AND ARE RECOMMENDED FOR 'GOOD FOR CONSTRUCTION'.

SIGN: \_\_\_\_\_  
 DATE: \_\_\_\_\_  
 NAME: \_\_\_\_\_

GENERAL CONSULTANTS FOR NAGPUR METRO RAIL PROJECT

Church House, Above SBI Bank, First floor, CK Naidu Marg, Anand Nagar Civil Lines Nagpur- 440001

**SYSTRA** **AECOM** **egis** **PRITES**

DETAIL DESIGN CONSULTANT

**FOUNTAINHEAD**

ARCHITECTURE INTERIOR & LANDSCAPE  
 C-9/9148, VASANT KUNJ, NEW DELHI  
 PH: 011-26891534, 26124540, 26124543. FAX: 26898459  
 Email: office@studiofountainhead.com

VARSHA DESIGNED BY      RENU BALA CHECKED BY      SUSHREE MATHUR APPROVED BY

**NAGPUR METRO RAIL CORPORATION LTD.**  
 Metro House, 28/2, Anand Nagar, C K Naidu Road, Civil Lines, Nagpur - 440001

**N1DDC D-01**

ROLLING STOCK DEPOT AT MIHAN

DRAWING TITLE: AUTO COACH WASH PLANT - PLANS


NMRCL DRAWING NO: N1DDCD01-DPOM-GFC-AR-2501

DATE: 05.11.2016      SCALE: 1:50      STATUS: FOR APPROVAL


SHEET NO: \_\_\_\_\_      R0

ARCHITECTURE


This drawing must not be either loaned, copied or otherwise reproduced in whole or in part or used for any purpose without the prior written permission of NMRCL.

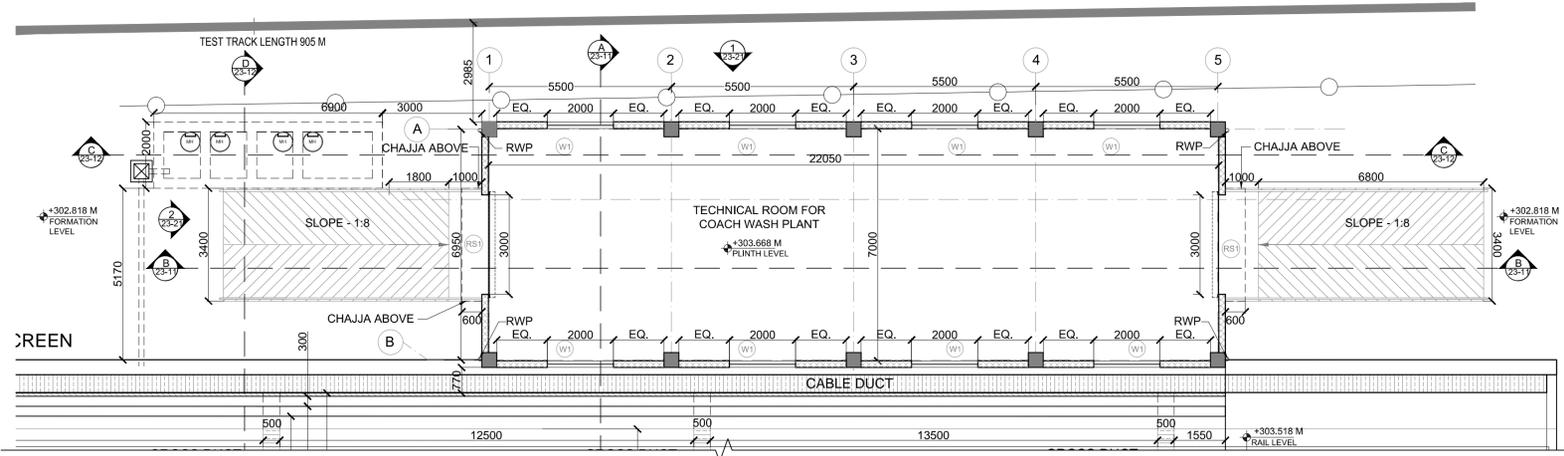


TECHNICAL ROOM GROUND FLOOR PLAN

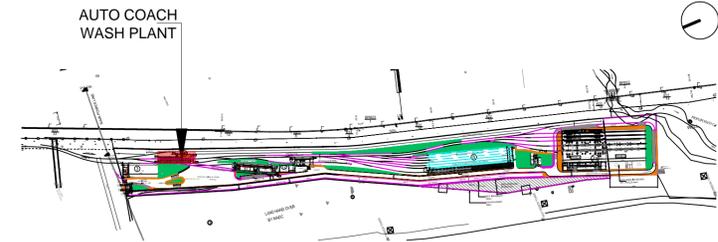

AUTO COACH WASH PLANT

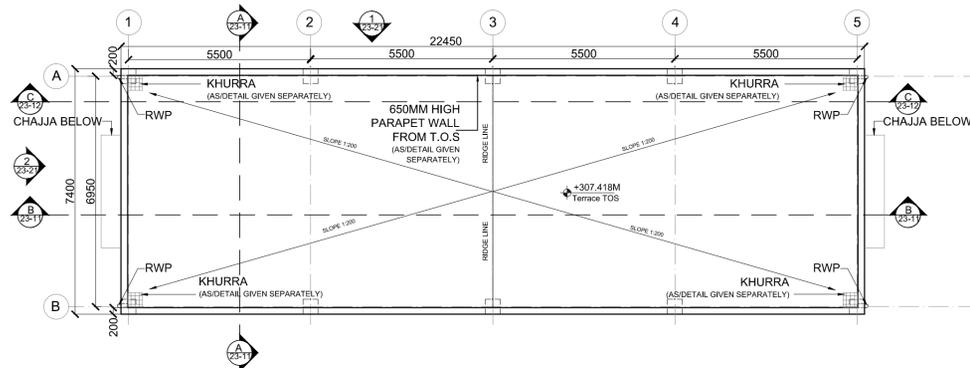

TECHNICAL ROOM ROOF PLAN

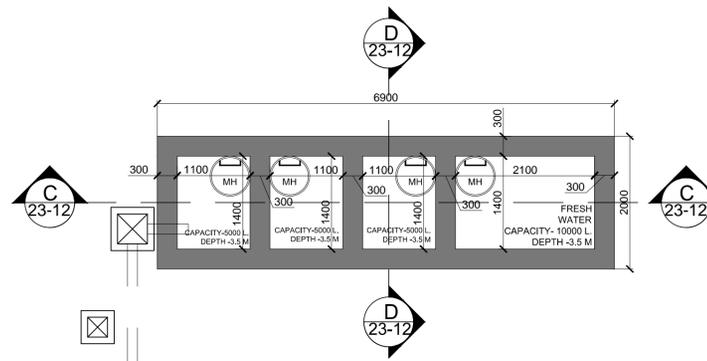

LOWER LEVEL PLAN OF UG TANK  
SCALE - 1:50

ROOM SCHEDULE (GROUND FLOOR)

S.NO.	ROOM NAME	SIZE(MM)	AREA(SQM)
1.	TECHNICAL ROOM FOR COACH WASH PLANT	22000 X 7000	154

WINDOW/GLAZING SCHEDULE

ITEM NO.	OPENING		SILL LEVEL	LINTEL LEVEL	DESCRIPTION
	WIDTH	HEIGHT			
W1	2000	1200	900	2100	ALUMINUM WINDOW

SCHEDULE OF FINISHES  
GROUND FLOOR

S. NO.	SPACES NAME	FLOORING	SKIRTING	INTERNAL WALLS	EXTERNAL FINISH
1	TECHNICAL ROOM FOR ACW PLANT	IPS FLOORING	IPS SKIRTING	ACRYLIC EMULSION	TEXTURED PAINT

DOOR SCHEDULE

ITEM NO.	OPENING		SILL LEVEL	LINTEL LEVEL	ROOM NAME	DESCRIPTION
	WIDTH	HEIGHT				
RS1	3000	3000	-	3000	TECHNICAL ROOM	POWER OPERATED METAL ROLLING SHUTTER

GENERAL NOTES:

- ALL DIMENSIONS ARE IN MILLIMETERS & LEVELS ARE IN METERS UNLESS OTHERWISE STATED.
- ALL DIMENSIONS ARE TO BE READ AND NOT MEASURED.
- ANY DISCREPANCIES MUST BE BROUGHT TO THE NOTICE OF THE NMRC BEFORE EXECUTION OF WORK AT SITE.
- THIS DRAWING MUST BE READ IN CONJUNCTION WITH ALL RELEVANT ARCHITECTURAL, STRUCTURAL, PLUMBING & FIRE FIGHTING, ELECTRICAL AND TRAFFIC MANAGEMENT DRAWINGS.
- ALL DOOR/WINDOW CILL & LINTEL LEVELS ARE MEASURED FROM MAIN FLOOR FINISHED LEVELS.

REFERENCE DRAWINGS	
Dwg. No.	Description

DESCRIPTION OF REVISIONS				
REV.	DESCRIPTION	DATE	NAME	SIGN.

**NO OBJECTION**

**NAGPUR METRO RAIL CORP.LTD.**  
Metro House, 28/2, Anand Nagar, C K Naidu Road, Civil Lines, Nagpur - 440001

DGM / E&M      Sr.DGM / Civil      CPM / RS

THE RESPONSIBILITY OF OVERALL CORRECTNESS OF DESIGN AND DRAWINGS RESTS WITH THE DDC. FORWARDED FOR APPROVAL AND ISSUE OF GOOD FOR CONSTRUCTION DRAWINGS.

(CHIEF ARCHITECT) (PROJECT LEADER)

THIS DRAWING INCLUDING ITS DESIGN AND DETAILING HAS BEEN CHECKED INDEPENDENTLY AND FOUND SUITABLE FOR THE EXECUTION PURPOSE AND ARE RECOMMENDED FOR 'GOOD FOR CONSTRUCTION'.

SIGN: \_\_\_\_\_  
DATE: \_\_\_\_\_  
NAME: \_\_\_\_\_

GENERAL CONSULTANTS FOR NAGPUR METRO RAIL PROJECT

Church House, Above SBI Bank, First floor, CK Naidu Marg, Anand Nagar Civil Lines Nagpur- 440001

**SYSTRA AECOM egis RITES**

DETAIL DESIGN CONSULTANT

**FOUNTAINHEAD**

ARCHITECTURE INTERIOR & LANDSCAPE  
C-9/9148, VASANT KUNJ, NEW DELHI  
PH: 011-26891534, 26124540, 26124543. FAX: 26898459  
Email: office@studiofountainhead.com

VARSHA DESIGNED BY      RENU BALA CHECKED BY      SUSHREE MATHUR APPROVED BY

**NAGPUR METRO RAIL CORPORATION LTD.**  
Metro House, 28/2, Anand Nagar, C K Naidu Road, Civil Lines, Nagpur - 440001

**N1DDC D-01**




ROLLING STOCK DEPOT AT MIHAN  
DRAWING TITLE: AUTO COACH WASH PLANT - PLANS (TECHNICAL ROOM & UG TANK)  
NMRC DRAWING NO: N1DDC01-DPOM-GFC-AR-2502

DATE: 05.11.2016      SCALE: 1:100      STATUS: FOR APPROVAL

SHEET NO: \_\_\_\_\_      R0

ARCHITECTURE

This drawing must not be either loaned, copied or otherwise reproduced in whole or in part or used for any purpose without the prior written permission of NMRC.

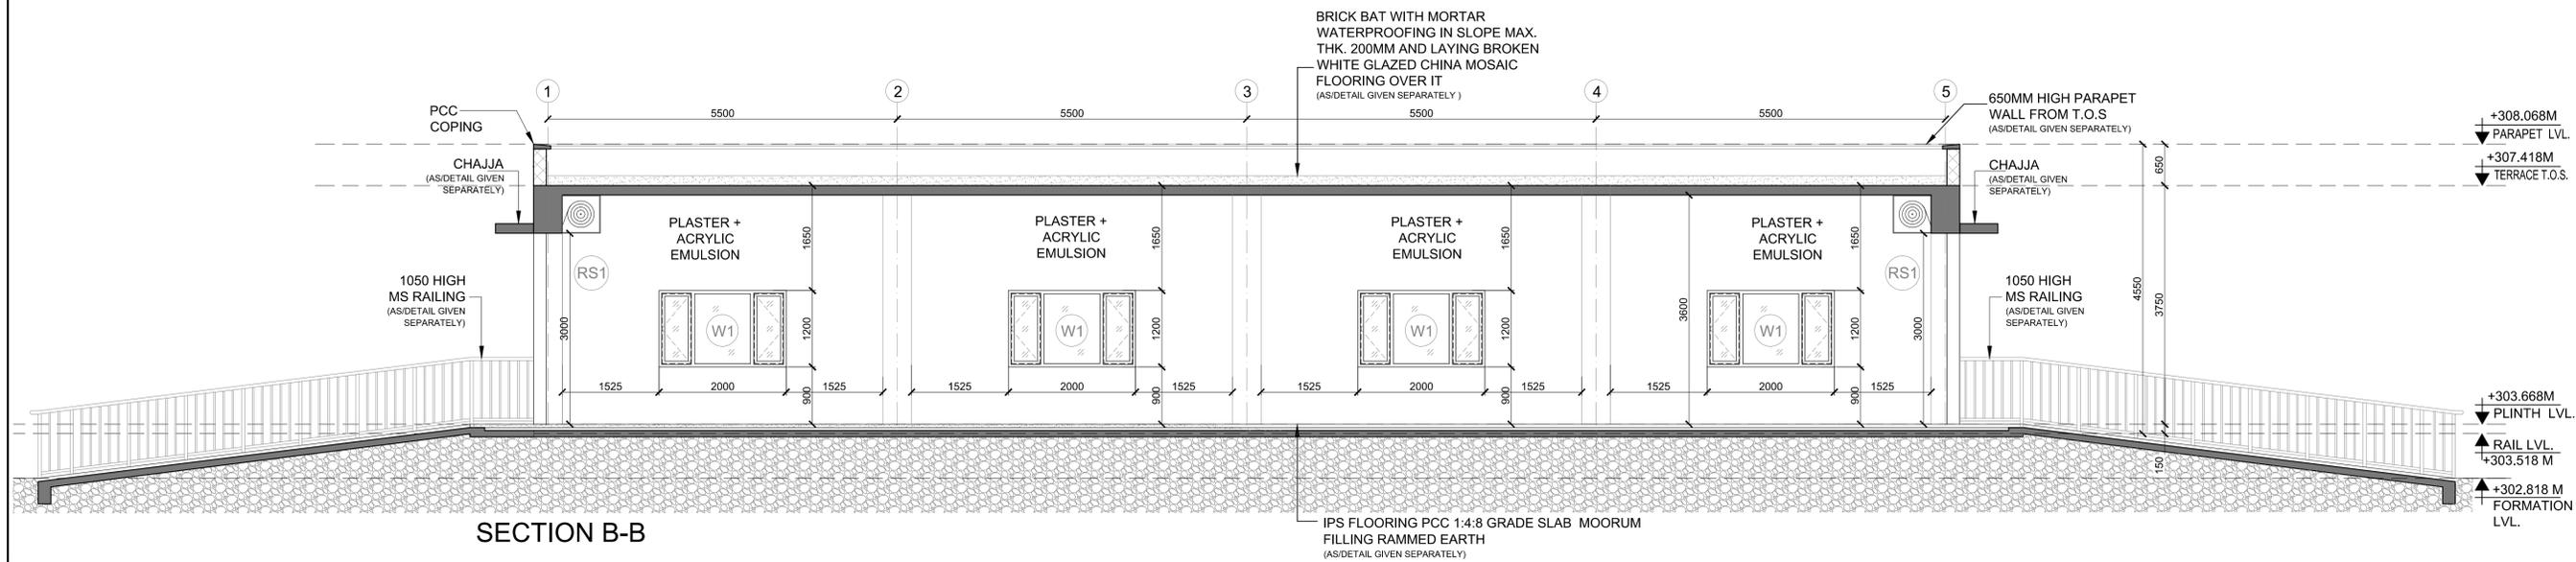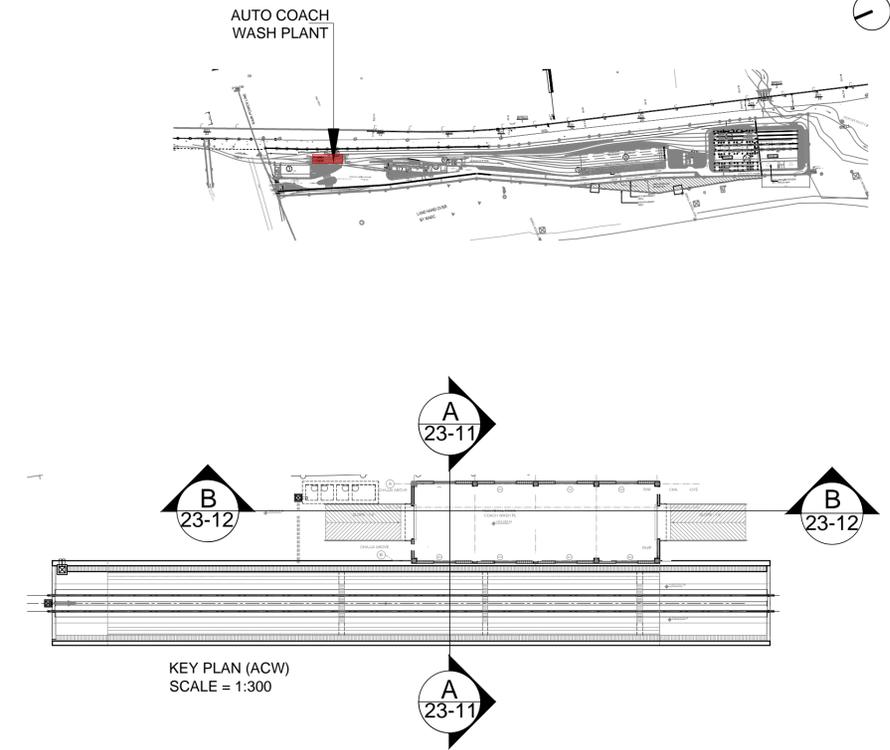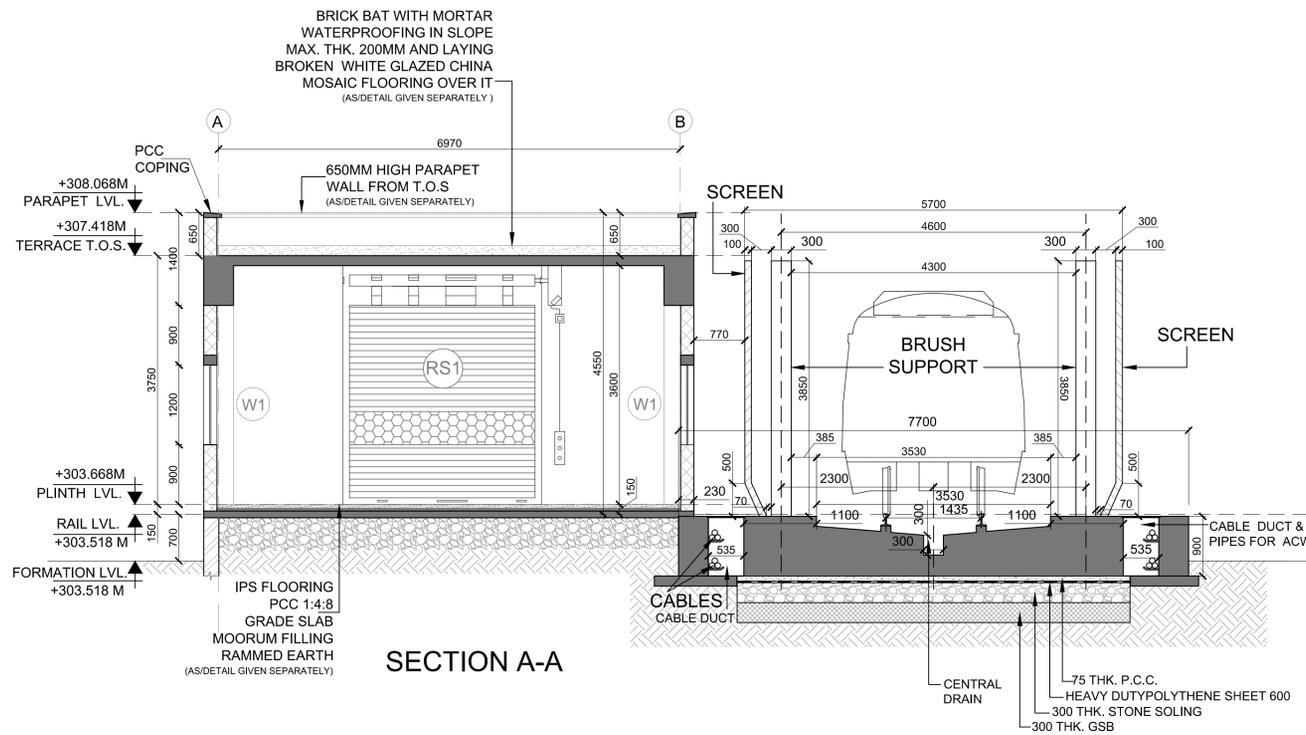

GENERAL NOTES:

- ALL DIMENSIONS ARE IN MILLIMETERS & LEVELS ARE IN METERS UNLESS OTHERWISE STATED.
- ANY DISCREPANCIES MUST BE BROUGHT TO THE NOTICE OF THE ARCHITECT BEFORE EXECUTION OF WORK AT SITE.
- THIS DRAWING MUST BE READ IN CONJUNCTION WITH ALL RELEVANT ARCHITECTURAL, STRUCTURAL, PLUMBING & FIRE FIGHTING, ELECTRICAL AND TRAFFIC MANAGEMENT DRAWINGS.
- ALL DOOR/WINDOW CILL & LINTEL LEVELS ARE MEASURED FROM MAIN FLOOR FINISHED LEVELS.

REFERENCE DRAWINGS	
Dwg. No.	Description

DESCRIPTION OF REVISIONS				
REV.	DESCRIPTION	DATE	NAME	SIGN.

**NO OBJECTION**

**NAGPUR METRO RAIL CORP. LTD.**  
Metro House, 28/2, Anand Nagar, C K Naidu Road, Civil Lines, Nagpur - 440001

DGM / E&M      Sr.DGM / Civil      CPM / RS

THE RESPONSIBILITY OF OVERALL CORRECTNESS OF DESIGN AND DRAWINGS RESTS WITH THE DDC. FORWARDED FOR APPROVAL AND ISSUE OF GOOD FOR CONSTRUCTION DRAWINGS.

(CHIEF ARCHITECT) (PROJECT LEADER)

THIS DRAWING INCLUDING ITS DESIGN AND DETAILING HAS BEEN CHECKED INDEPENDENTLY AND FOUND SUITABLE FOR THE EXECUTION PURPOSE AND ARE RECOMMENDED FOR 'GOOD FOR CONSTRUCTION'.

SIGN: \_\_\_\_\_  
DATE: \_\_\_\_\_  
NAME: \_\_\_\_\_

GENERAL CONSULTANTS FOR  
NAGPUR METRO RAIL PROJECT

Church House, Above SBI Bank,  
First floor, CK Naidu Marg, Anand Nagar  
Civil Lines Nagpur - 440001

**SYSTRA** **AECOM** **egis** **PRITES**

DETAIL DESIGN CONSULTANT

**FOUNTAINHEAD**

ARCHITECTURE INTERIOR & LANDSCAPE  
C-9/9148, VASANT KUNJ, NEW DELHI  
PH: 011-26891534, 26124540, 26124543. FAX: 26898459  
Email: office@studiofountainhead.com

VARSHA DESIGNED BY      RENU BALA CHECKED BY      SUSHREE MATHUR APPROVED BY

**NAGPUR METRO RAIL CORPORATION LTD.**  
Metro House, 28/2, Anand Nagar, C K Naidu Road, Civil Lines, Nagpur - 440001

**N1DDC D-01**

ROLLING STOCK DEPOT AT MIHAN

DRAWING TITLE: AUTO COACH WASH PLANT - SECTIONS







NMRCL DRAWING NO: N1DDC01-DPOM-GFC-AR-2511

DATE: 05.11.2016      SCALE: 1:50      STATUS: FOR APPROVAL

SHEET NO: \_\_\_\_\_      R0

ARCHITECTURE

This drawing must not be either loaned, copied or otherwise reproduced in whole or in part or used for any purpose without the prior written permission of NMRCL.

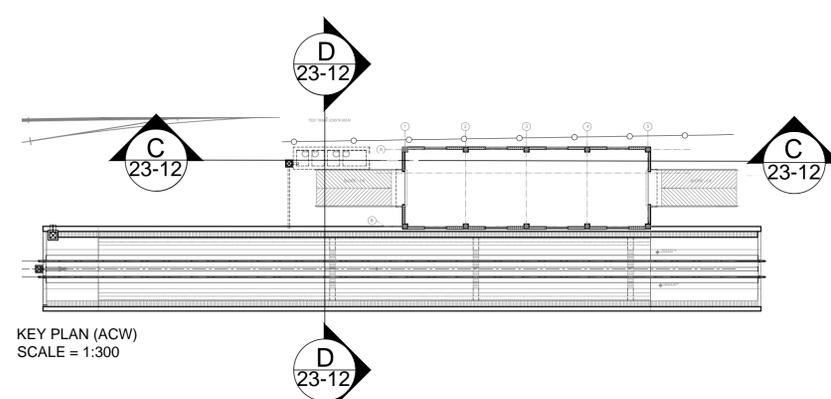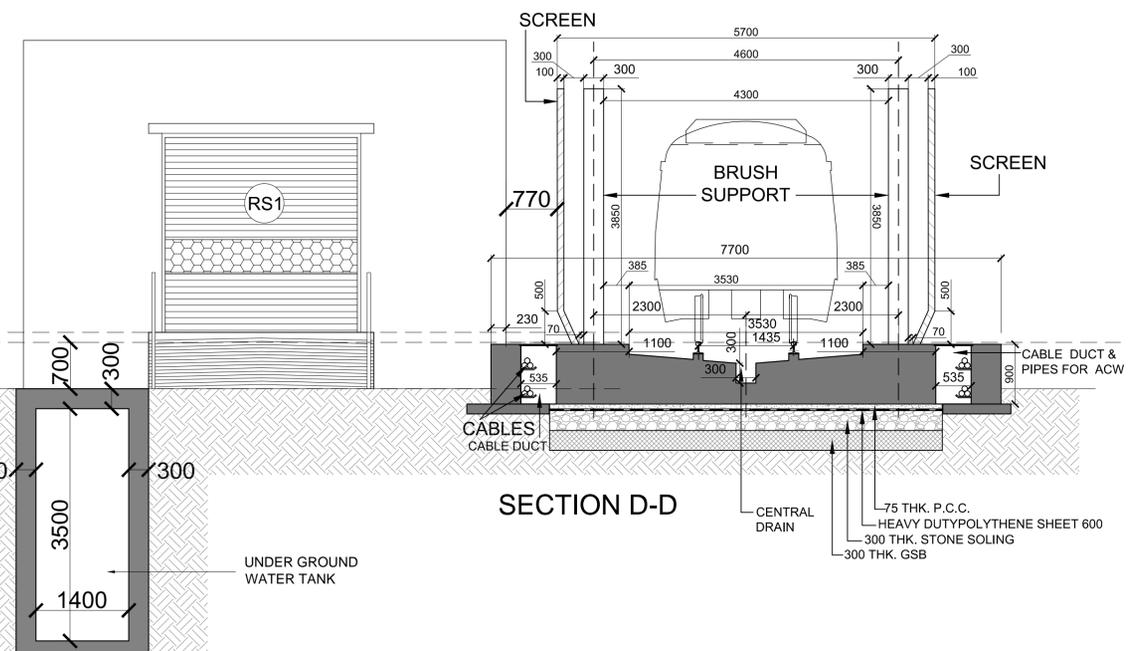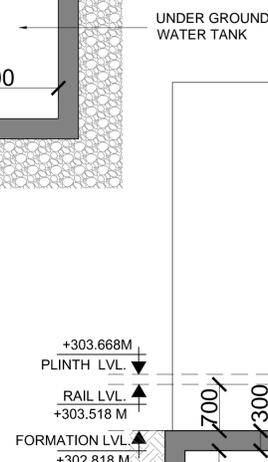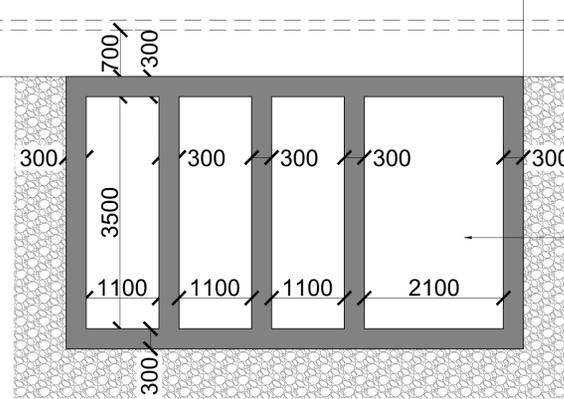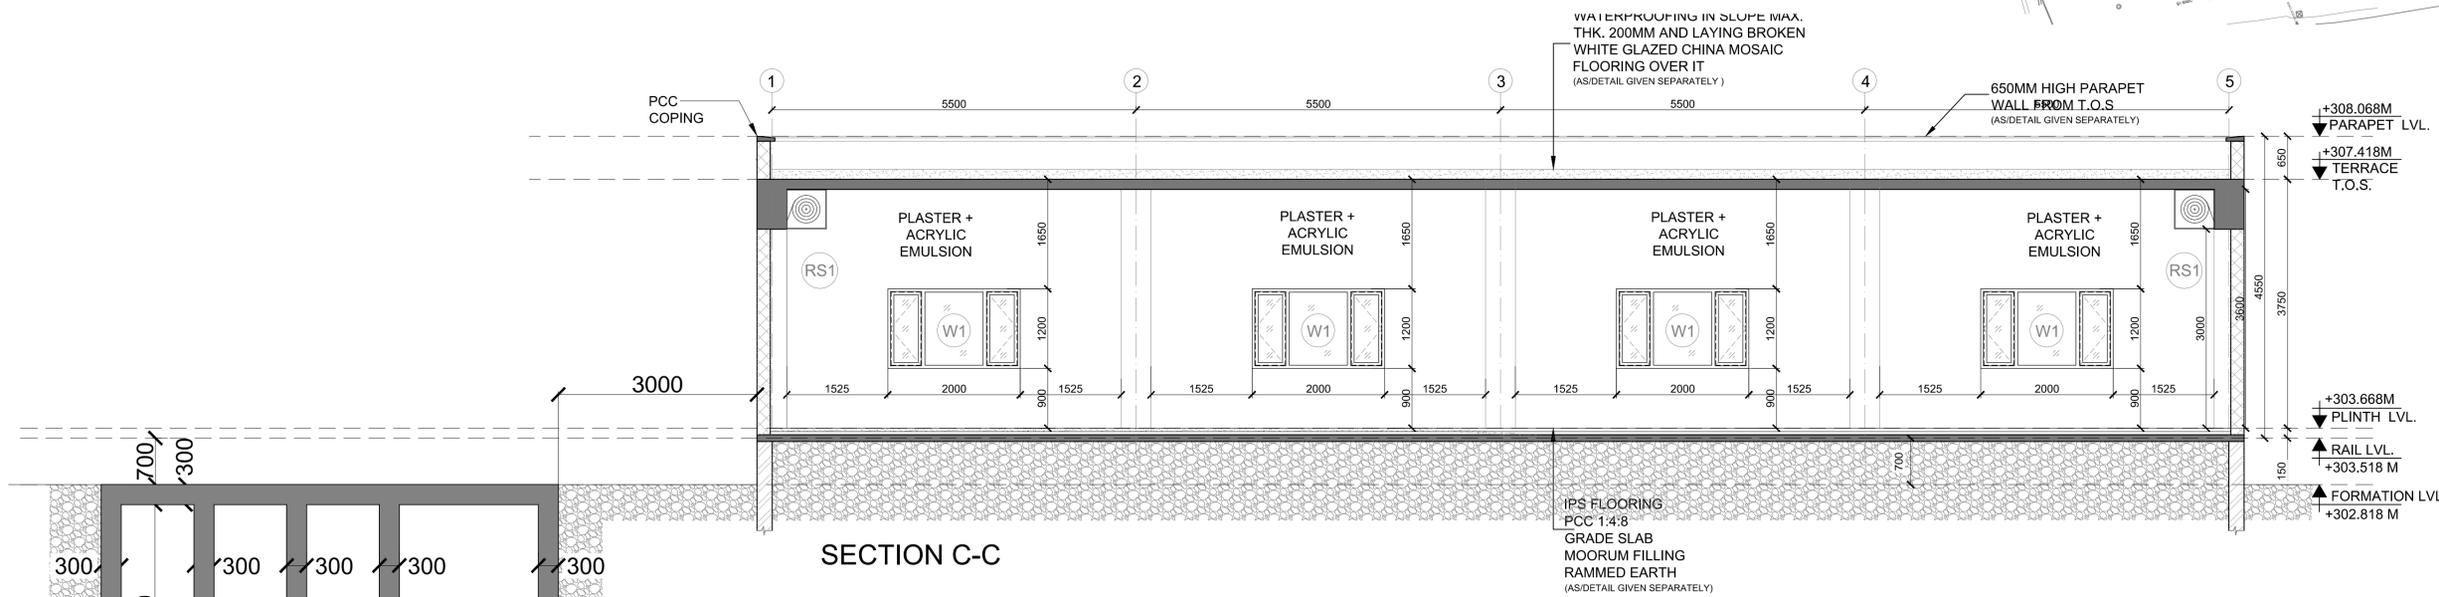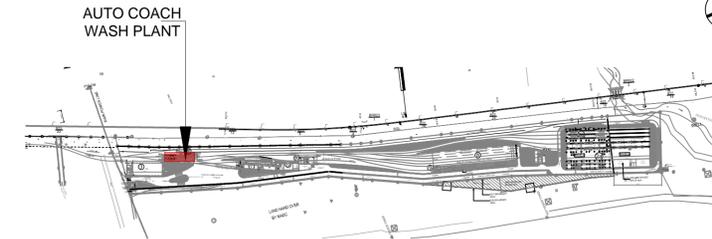

THIS DRAWING IS THE PROPERTY OF NAGPUR METRO RAIL CORPORATION LTD.

GENERAL NOTES:

- ALL DIMENSIONS ARE IN MILLIMETERS & LEVELS ARE IN METERS UNLESS OTHERWISE STATED.
- ALL DIMENSIONS ARE TO BE READ AND NOT MEASURED.
- ANY DISCREPANCIES MUST BE BROUGHT TO THE NOTICE OF THE INMRCL BEFORE EXECUTION OF WORK AT SITE.
- THIS DRAWING MUST BE READ IN CONJUNCTION WITH ALL RELEVANT ARCHITECTURAL, STRUCTURAL, PLUMBING & FIRE FIGHTING, ELECTRICAL AND TRAFFIC MANAGEMENT DRAWINGS.
- ALL DOOR/WINDOW CILL & LINTEL LEVELS ARE MEASURED FROM MAIN FLOOR FINISHED LEVELS.

REFERENCE DRAWINGS	
Dwg. No.	Description

DESCRIPTION OF REVISIONS				
REV.	DESCRIPTION	DATE	NAME	SIGN.

**NO OBJECTION**

**NAGPUR METRO RAIL CORP.LTD.**  
Metro House, 28/2, Anand Nagar, C K Naidu Road, Civil Lines, Nagpur - 440001

DGM / E&M      Sr.DGM / Civil      CPM / RS

THE RESPONSIBILITY OF OVERALL CORRECTNESS OF DESIGN AND DRAWINGS RESTS WITH THE DDC. FORWARDED FOR APPROVAL AND ISSUE OF GOOD FOR CONSTRUCTION DRAWINGS.

(CHIEF ARCHITECT) (PROJECT LEADER)

THIS DRAWING INCLUDING ITS DESIGN AND DETAILING HAS BEEN CHECKED INDEPENDENTLY AND FOUND SUITABLE FOR THE EXECUTION PURPOSE AND ARE RECOMMENDED FOR 'GOOD FOR CONSTRUCTION'.

SIGN: \_\_\_\_\_  
DATE: \_\_\_\_\_  
NAME: \_\_\_\_\_

GENERAL CONSULTANTS FOR NAGPUR METRO RAIL PROJECT

Church House, Above SBI Bank, First floor, CK Naidu Marg, Anand Nagar Civil Lines Nagpur- 440001

**SYSTA AECOM egis RITES**

DETAIL DESIGN CONSULTANT

**FOUNTAINHEAD**

ARCHITECTURE INTERIOR & LANDSCAPE  
C-9/9148, VASANT KUNJ, NEW DELHI  
PH: 011-26891534, 26124540, 26124543. FAX: 26898459  
Email: office@studiofountainhead.com

VARSHA DESIGNED BY      RENU BALA CHECKED BY      SUSHREE MATHUR APPROVED BY

**NAGPUR METRO RAIL CORPORATION LTD.**  
Metro House, 28/2, Anand Nagar, C K Naidu Road, Civil Lines, Nagpur - 440001

**N1DDC D-01**

ROLLING STOCK DEPOT AT MIHAN

DRAWING TITLE: AUTO COACH WASH PLANT - SECTIONS



NMRCL DRAWING NO: N1DDCD01-DPOM-GFC-AR-2512

DATE: 05.11.2016      SCALE: 1:50      STATUS: FOR APPROVAL

SHEET NO: \_\_\_\_\_      R0

ARCHITECTURE

This drawing must not be either loaned, copied or otherwise reproduced in whole or in part or used for any purpose without the prior written permission of NMRCL.

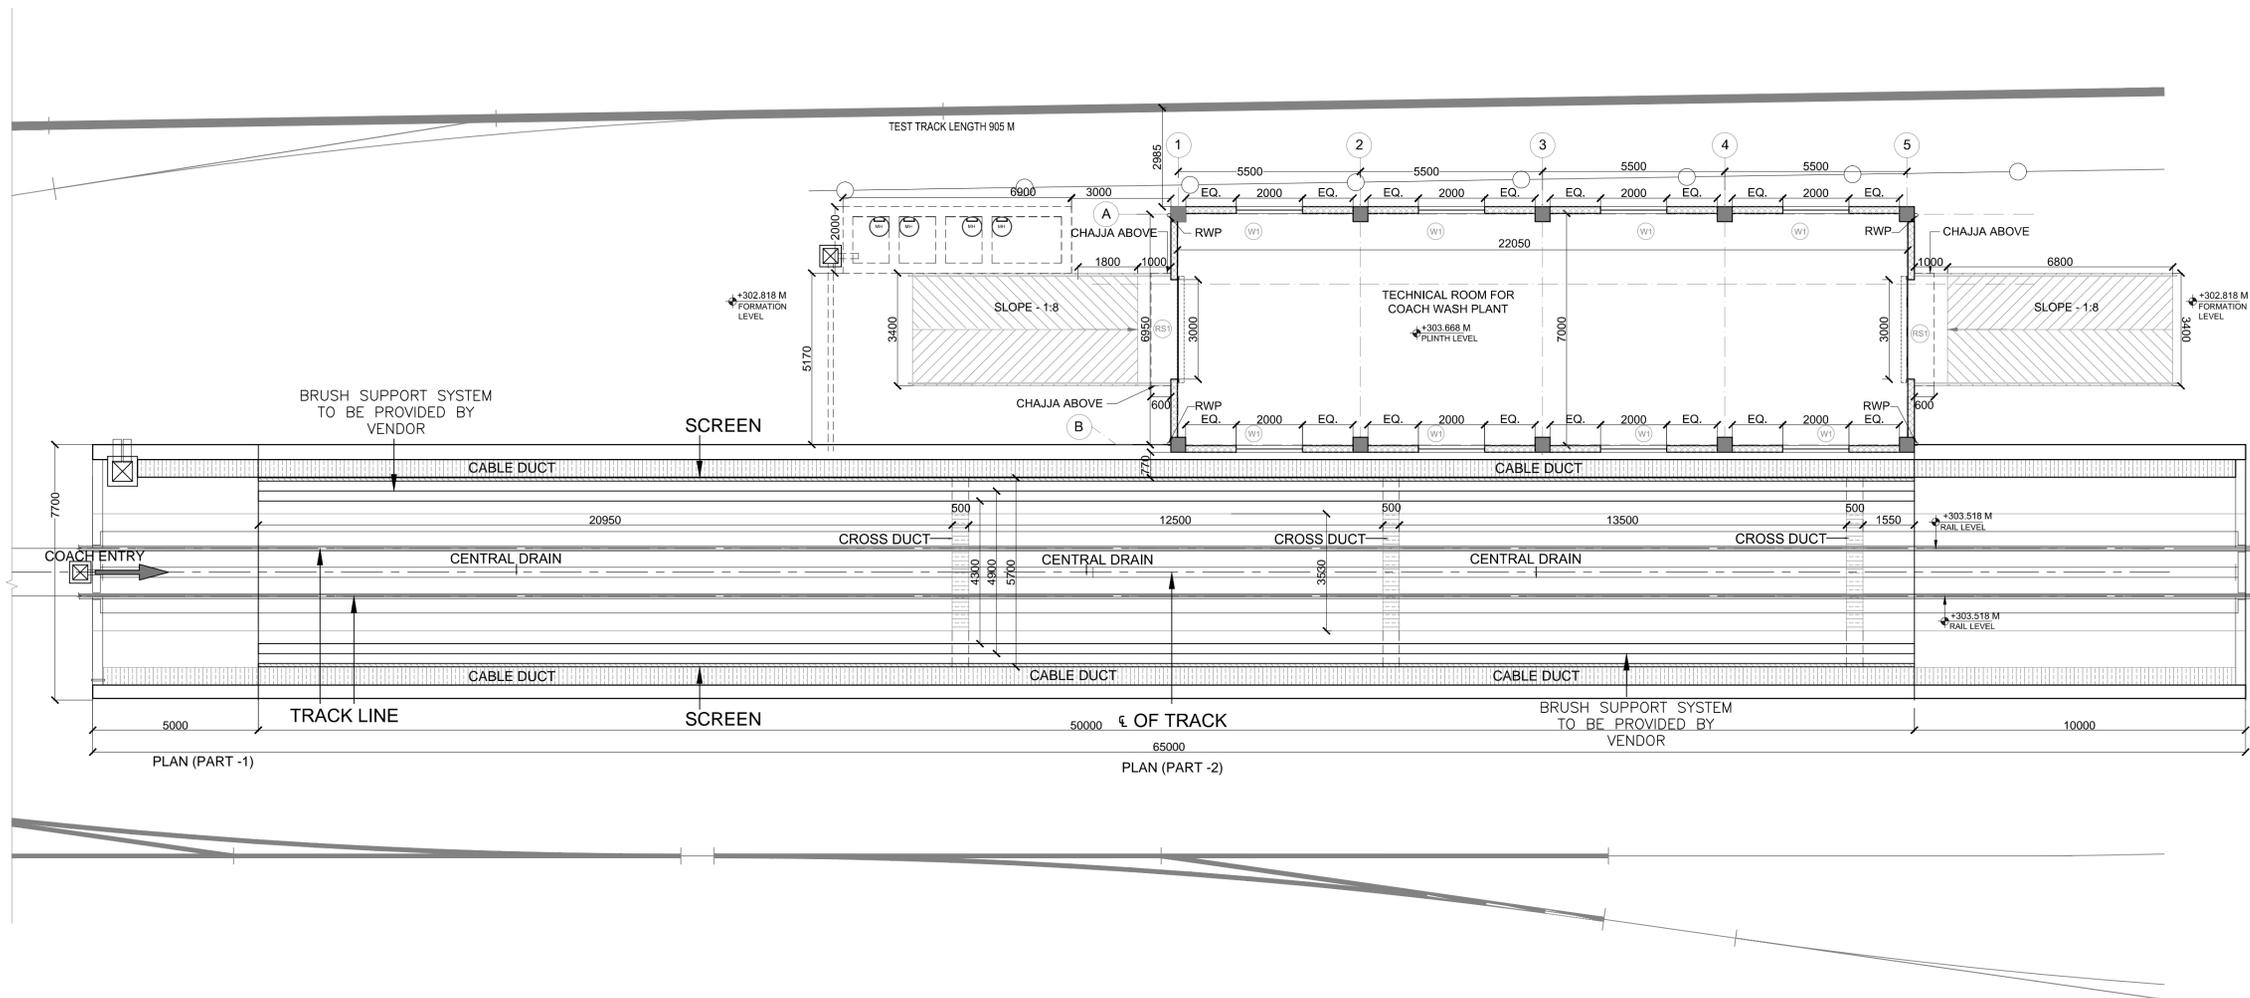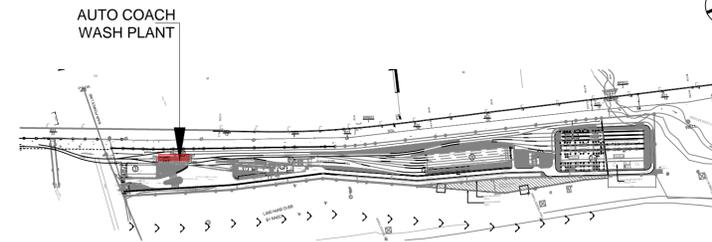

PRODUCED BY AN AUTODESK EDUCATIONAL PRODUCT

PRODUCED BY AN AUTODESK EDUCATIONAL PRODUCT

GENERAL NOTES:

1. ALL DIMENSIONS ARE IN MILLIMETERS & LEVELS ARE IN METERS UNLESS OTHERWISE STATED.
2. ALL DIMENSIONS ARE TO BE READ AND NOT MEASURED.
3. ANY DISCREPANCIES MUST BE BROUGHT TO THE NOTICE OF THE NMRC BEFORE EXECUTION OF WORK AT SITE.
4. THIS DRAWING MUST BE READ IN CONJUNCTION WITH ALL RELEVANT ARCHITECTURAL, STRUCTURAL, PLUMBING & FIRE FIGHTING, ELECTRICAL AND TRAFFIC MANAGEMENT DRAWINGS.
5. ALL DOOR/WINDOW CILL & LINTEL LEVELS ARE MEASURED FROM MAIN FLOOR FINISHED LEVELS.

REFERENCE DRAWINGS	
Dwg. No.	Description

DESCRIPTION OF REVISIONS				
REV	DESCRIPTION	DATE	NAME	SIGN

**NO OBJECTION**

**NAGPUR METRO RAIL CORP.LTD.**  
Metro House, 28/2, Anand Nagar, C K Naidu Road, Civil Lines, Nagpur - 440001

DGM / E&M	Sr.DGM / Civil	CPM / RS
-----------	----------------	----------

THE RESPONSIBILITY OF OVERALL CORRECTNESS OF DESIGN AND DRAWINGS RESTS WITH THE DDC. FORWARDED FOR APPROVAL AND ISSUE OF GOOD FOR CONSTRUCTION DRAWINGS.

(CHIEF ARCHITECT) (PROJECT LEADER)

THIS DRAWING INCLUDING ITS DESIGN AND DETAILING HAS BEEN CHECKED INDEPENDENTLY AND FOUND SUITABLE FOR THE EXECUTION PURPOSE AND ARE RECOMMENDED FOR 'GOOD FOR CONSTRUCTION'.

SIGN: \_\_\_\_\_  
DATE: \_\_\_\_\_  
NAME: \_\_\_\_\_

GENERAL CONSULTANTS FOR NAGPUR METRO RAIL PROJECT

Church House, Above SBI Bank, First floor, CK Naidu Marg, Anand Nagar Civil Lines Nagpur- 440001

**SYSTA AECOM egis RITES**

DETAIL DESIGN CONSULTANT

**FOUNTAINHEAD**

ARCHITECTURE INTERIOR & LANDSCAPE  
C-9/9148, VASANT KUNJ, NEW DELHI  
PH: 011-26891534, 26124540, 26124543. FAX: 26898459  
Email: office@studiofountainhead.com

VARSHA DESIGNED BY	RENU BALA CHECKED BY	SUSHREE MATHUR APPROVED BY
-----------------------	-------------------------	-------------------------------

**NAGPUR METRO RAIL CORPORATION LTD.**  
Metro House, 28/2, Anand Nagar, C K Naidu Road, Civil Lines, Nagpur - 440001

**N1DDC D-01**

ROLLING STOCK DEPOT AT MIHAN

DRAWING TITLE: AUTO COACH WASH PLANT - PART SITE PLAN

NMRC DRAWING NO: N1DDC01-DPOM-GFC-AR-2503

DATE: 05.11.2016	SCALE: 1:100	STATUS: FOR APPROVAL
SHEET NO:		R0

ARCHITECTURE

This drawing must not be either loaned, copied or otherwise reproduced in whole or in part or used for any purpose without the prior written permission of NMRC.